


**BID SET
12/10/2010
ADDENDUM
NO. 2**

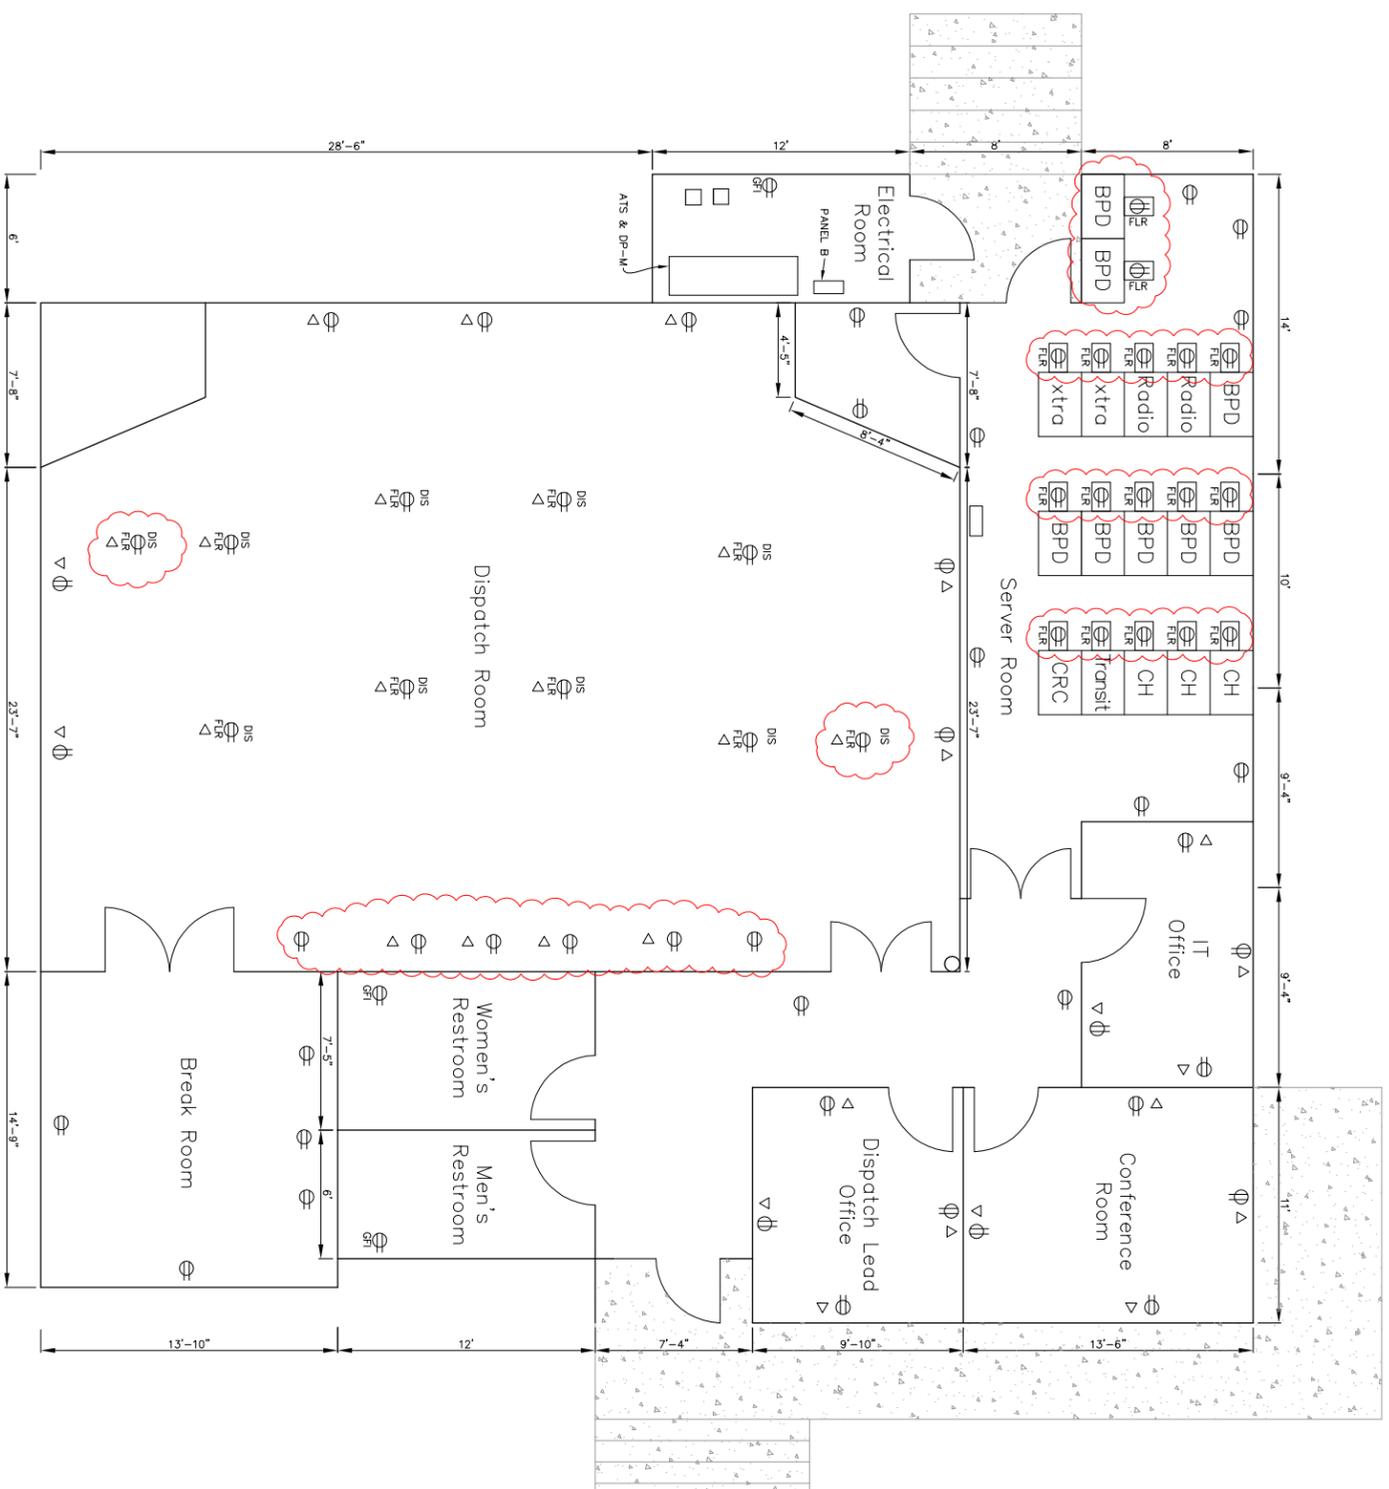

▲ DATA TO BE INSTALLED BY OTHERS
 ⊕ STD. DUPLEX RECEPTACLE
 ⊕ DISPATCH OUTLET REC./W/ #4 30A TWIST LOCK
 ⊕ PROVIDE 30A TWIST LOCK FLP. REC. FOR SERVER RACKS @ FLOOR

NOTE:
 PROVIDE COMPLETE WIRING TO THE ALL RECEPTABLES & DISPATCH OUTLETS WITH BALANCED LOAD CIRCUIT FROM DISPATCH PANEL-B. LOCATION AND ELEVATION OF REC. & OUTLETS ARE APPROXIMATE AND NEED FIELD VERIFICATION & COORDINATION WITH END USER PROVIDE ADDITIONAL REC & DISPATCH OUTLET IF REQUIRED PER CITY AUTHORITY.
 PROVIDE PANEL SCHEDULE COPY AT THE INSIDE DOOR OF ALL PANELS.
 TELEPHONE OUTLETS TO BE COORDINATED WITH END USERS.
 BREAK ROOM SHALL HAVE HOOK-UP REC. FOR MICROWAVE, REFRIGERATOR
 RESTROOMS SHALL HAVE HAND DRYER HOOK-UP.

REVISIONS ARE CLOUD MARKED

SPECIAL NOTE:

ALL WORKS AND MATERIALS SHALL BE PROVIDED WITH NEMA STANDARD, UL RATED AND PER LATEST NEC AND OBC AND ALL CALIFORNIA AMENDMENTS
 CONTRACTOR NEEDS TO PROVIDE SHOP DRAWING FOR LIGHTING, RECEPTABLES, INTERIOR BUILDING WIRING CIRCUITS & PANEL SCHEDULES FOR CITY ENGINEERS REVIEW PRIOR TO COMMENCEMENT OF WORK

**BUILDING
D**

<p>Underground Service Alert Call: TOLL FREE 1-880-422-4133 TWO WORKING DAYS BEFORE YOU DIG</p>		<p>RECOMMENDED FOR APPROVAL DATE: _____ CHECKED BY: PY DATE: _____</p>		<p>SEAL</p>		<p>APPROVED BY _____ DATE _____ CONSULTING ENGINEER</p>		<p>Urban Logic Consultants 4537 Ridge Park Drive, Suite 200 Temecula, California 92590 Tel: (951) 676-1944 Fax (951) 676-2054</p>		<p>CITY OF BEAUMONT BUILDING-D ELECTRICAL RENOVATION WORK</p>		<p>SHEET NO. 3 E-3 OF 5 SHTS. FILE NO. 1890</p>	
<p>DESIGNED BY _____ ENGINEER</p>		<p>DATE BY MARK _____</p>		<p>REVISIONS</p>		<p>DATE _____</p>		<p>APPROVAL DATE _____</p>		<p>CHECKED BY XX _____</p>		<p>DATE _____</p>	
<p>DRAWN BY AJAI _____</p>		<p>CHECKED BY XX _____</p>		<p>DATE _____</p>		<p>DATE _____</p>		<p>DATE _____</p>		<p>DATE _____</p>		<p>DATE _____</p>	

