


**BID SET
12/10/2010
ADDENDUM
NO. 2**

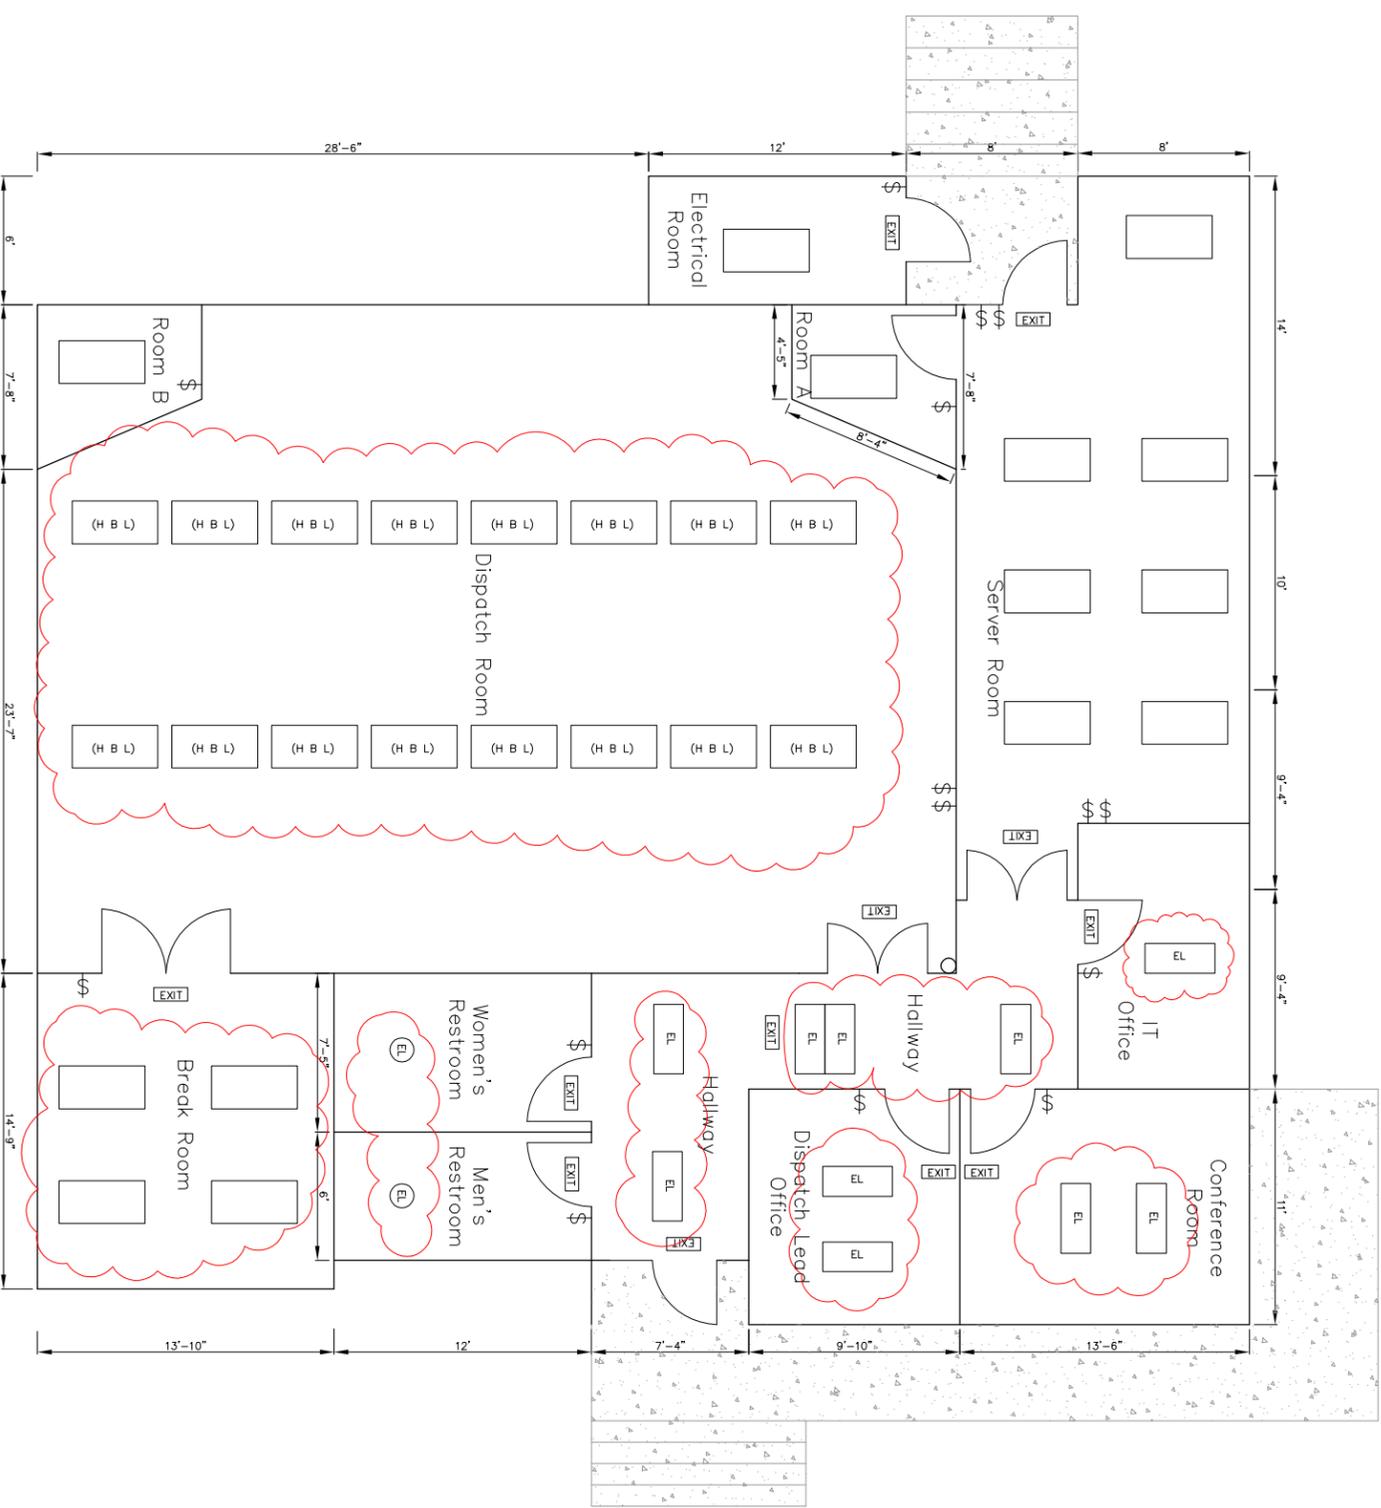

- REWIRE EXISTING LIGHTING FIXTURES W/
4# 4' LAMPS & REPLACE LAMPS
- REWIRE EXISTING LIGHTING FIXTURES &
REPLACE LAMPS @ RESTROOMS
- 4'-2LAMP T-8 WRAP
AROUND 4100K LAMPS
- REWIRE EXISTING HIGH BAY LIGHTING FIXTURES
W/ 2# 4' LAMPS & REPLACE LAMPS
- SINGLE POLE LIGHTING SWITCH
- EXIT SIGN

NOTE:

PROVIDE COMPLETE WIRING TO THE ALL LIGHTINGS INSIDE THE BUILDING-D FROM PANEL DP-M DEDICATED CIRCUITS FOR LIGHTINGS IN COMPLETE INCLUDING LAMP FIXTURES, FITTINGS AND ALL ACCESSORIES PER NEC AND ALL CALIFORNIA AMENDMENTS
 PROVIDE DIMMING BALLAST FOR DISPATCH ROOM
 PROVIDE OCCUPANCY SENSORE IN ALL AREAS
 LOCATION OF LIGHTING FIXTURES MAY BE PROVIDED BASED ON AREA SQ.FOOT REQUIREMENTS.
 ALL MATERIALS SHALL BE NEMA STANDARD & UL RATED. LOCATIONS ARE APPROXIMATE AND NEED FIELD VERIFICATION.
 PROVIDE ADDITIONAL LIGHTINGS, IF REQUIRED PER CITY AUTHORITY.
 PROVIDE PANEL SCHEDULE COPY AT THE INSIDE DOOR OF ALL PANELS.
 SUCCESSFUL BIDDER TO REVIEW EXISTING HVAC, PLUMBING, F.S. ETC. CONDITION PRIOR TO SHOP DRAWING DRAFTING.
 SUCCESSFUL BIDDER TO COORDINATE WITH HVAC SUB-CONTRACTOR ETC.
 SUCCESSFUL BIDDER/SUB-CONTRACTOR TO PROVIDE (2) SAMPLES OF EACH ITEM AS APPLICABLE ALONG WITH PRODUCT DATA SHEET (WITH SWITCH REC. ETC.) (1) ITEM WILL BE RETURNED TO SUB-CONTRACTOR AFTER AWARD OF CONTRACT PRIOR TO PROCUREMENT.

REVISIONS ARE CLOUD MARKED

SPECIAL NOTE:

ALL WORKS AND MATERIALS SHALL BE PROVIDED WITH NEMA STANDARD, UL RATED AND PER LATEST NEC AND ALL CALIFORNIA AMENDMENTS
 CONTRACTOR NEEDS TO PROVIDE SHOP DRAWING FOR LIGHTING, RECEPTACLES, INTERIOR BUILDING WIRING CIRCUITS & PANEL SCHEDULES FOR CITY ENGINEERS REVIEW PRIOR TO COMMENCEMENT OF WORK

**BUILDING
D**

Underground Service Alert
 Call: TOLL FREE
 1-880-422-4133
 TWO WORKING DAYS BEFORE YOU DIG

DATE BY MARK	REVISIONS	APPR. DATE	DATE
ENGINEER	CITY	CITY	CITY
DESIGNED BY	CHECKED BY	CHECKED BY	CHECKED BY
AWJ	AWJ	AWJ	AWJ

RECOMMENDED FOR APPROVAL	SEAL	APPROVED BY	DATE
CONSULTING ENGINEER			

Urban Logic Consultants
 45317 Ridge Park Drive, Suite 200
 Temecula, California 92590
 Tel: (951) 676-1944 Fax (951) 676-2054

CITY OF BEAUMONT
 BUILDING-D
 ELECTRICAL RENOVATION WORK
 FLOOR PLAN FOR LIGHTING

FOR CITY OF BEAUMONT

W/O.

SHEET NO. 4
 E-4
 OF 4 SHTS.
 FILE NO.
 1890